

REAR GARDEN CONCEPT PLAN 1:50 @ A2

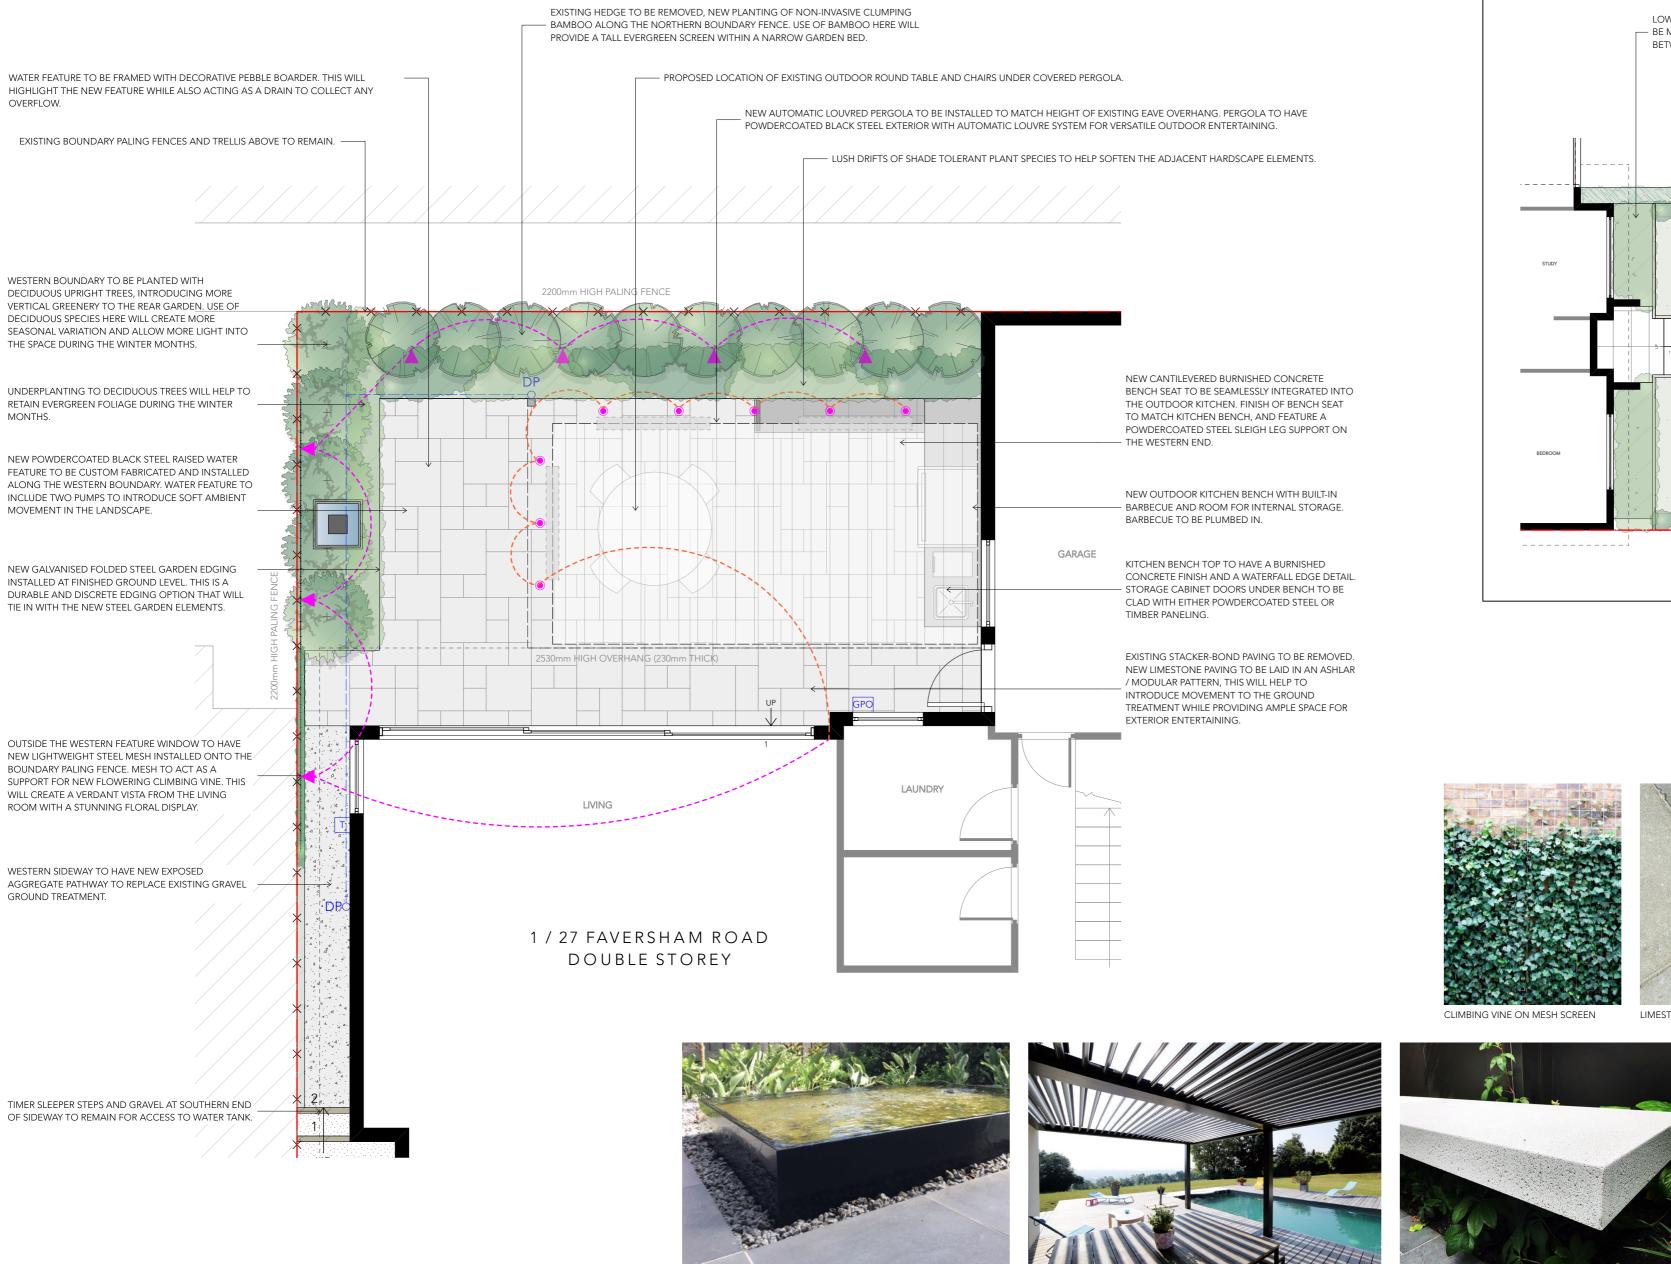

RAISED POWDERCOATED STEEL WATER FEATURE

FRONT GARDEN CONCEPT PLAN 1:100 @ A2



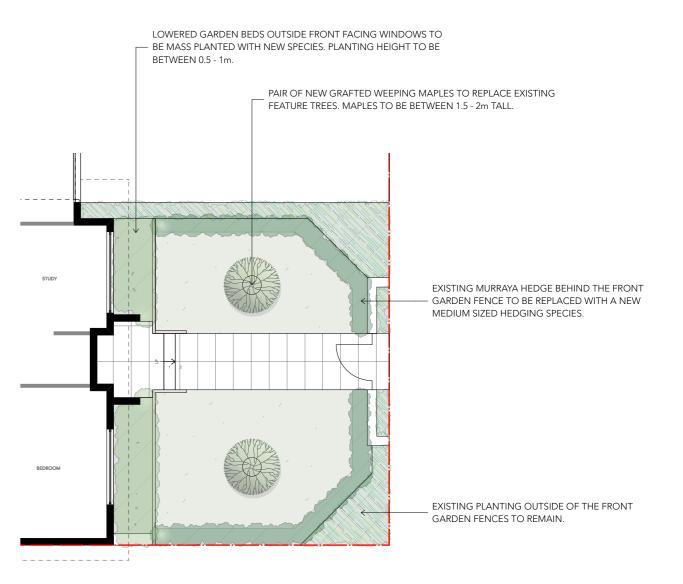






BAMBOO LINEAR SCREEN PLANTING

AUTOMATIC LOUVRED PERGOLA FOR COVERED OUTDOOR ENTERTAINING

CANTILEVERED CONCRETE BENCH SEAT



BUILT-IN BARBECUE ON CONCRETE BENCH TOP WITH WATERFALL EDGE, AND TIMBER OR STEEL CABINETRY

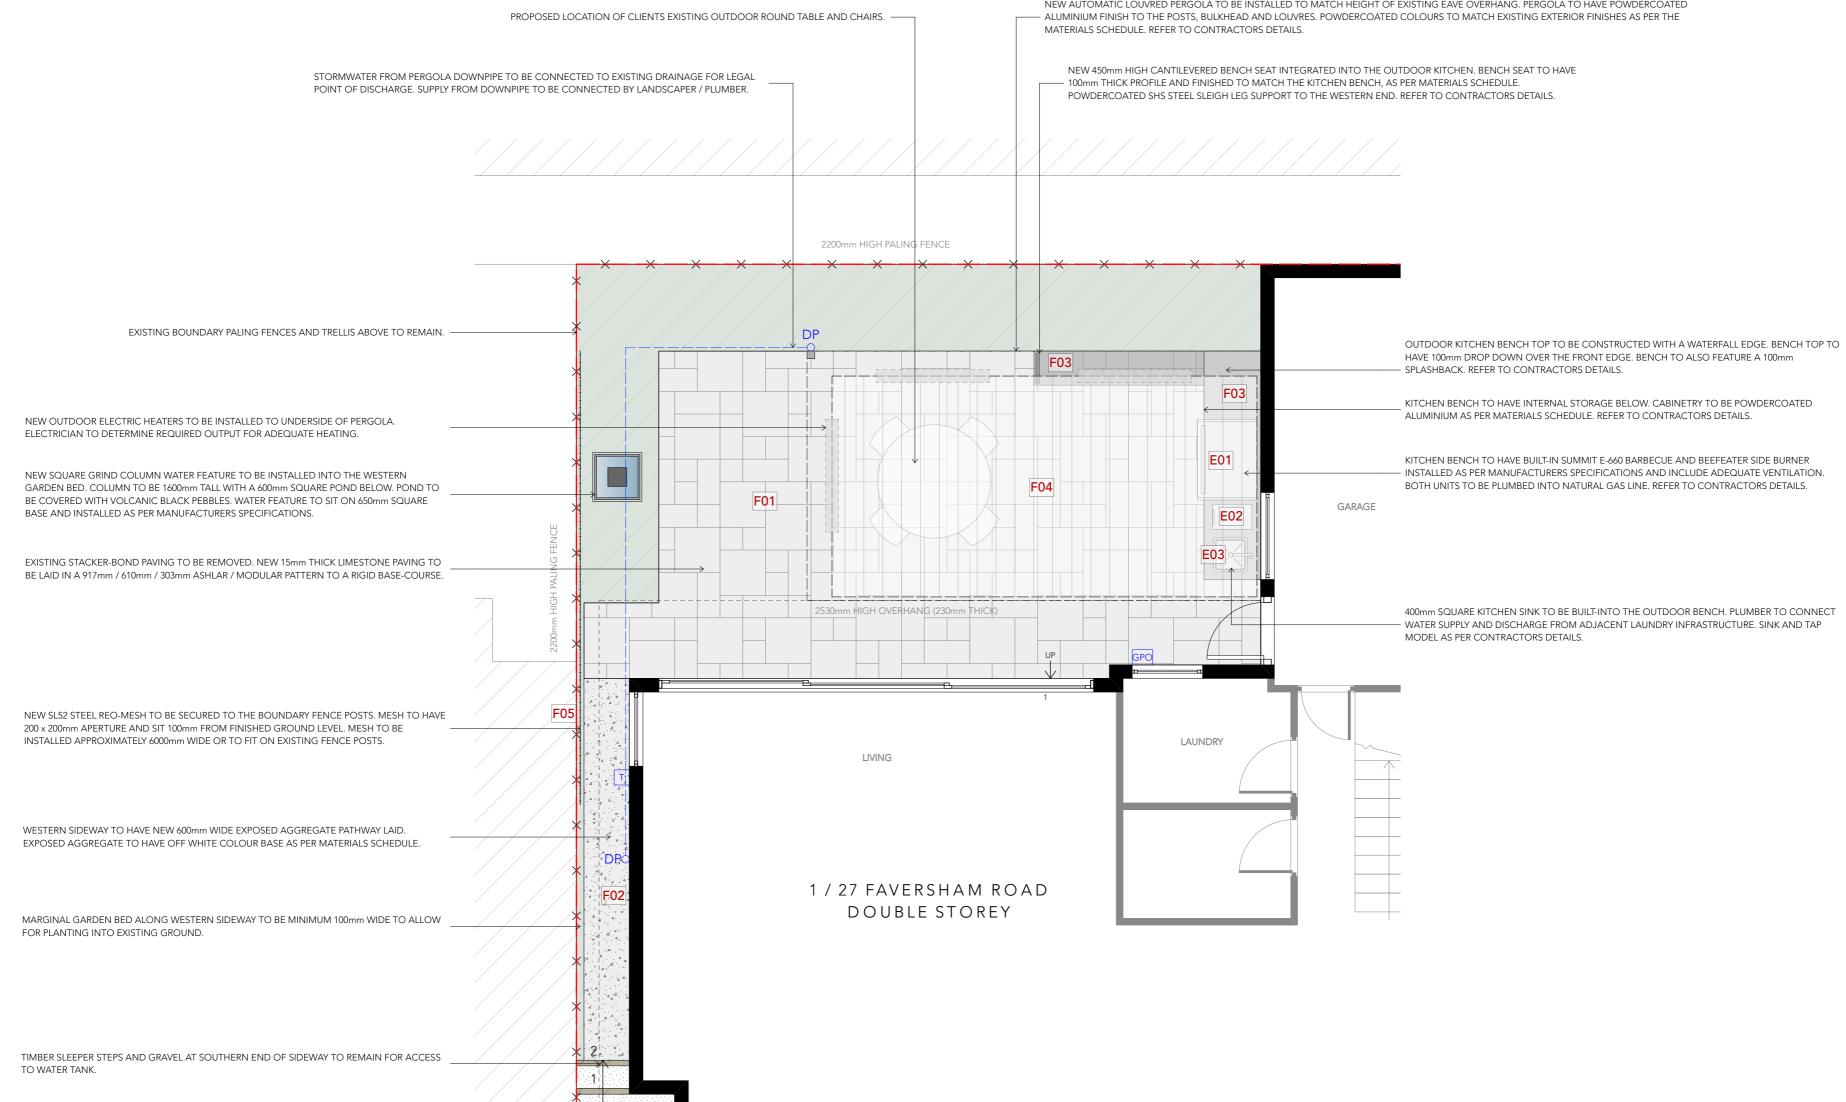



94 Milton Parade Malvern, Vic 3144 (03) 9017 4344 PH: EMAIL: admin@whytegardens.com.au WEB: www.whytegardens.com.au ABN: 51 121 922 361



IN ACCEPTING AND UTILISING THIS DOCUMENT THE RECIPIENT IN ACCEPTING AND UTILISING THIS DOCUMENT I HE RECIFIENT AGREES THAT WHYTE GARDENS ARN 51 121 922 331 RETAINS ALL COMMON LAW, STATUARY LAW AND OTHER RIGHTS INCLUDING COPYRIGHT AND INTELLECTUAL PROPERTY RIGHTS. THE RECIPIENT COPYRIGHT AND INTELLECTUAL PROPERTY RIGHTS. THE RECIPIENT COPYRIGHT AND INTELLECTUAL PROPERTY RIGHTS. THE RECIPIENT AGREES NOT TO USE THIS DOCUMENT FOR ANY PORPOSE OTHER THAN ITS INTENDED USE; TO WAIVE ALL CLAIMS AGAINST WHYTE GARDENS RESULTING FROM UNAUTHORISED CHANGES; OR TO REUSE THIS DOCUMENT ON OTHER PROJECTS WITHOUT PRIOR WRITTEN CONSENT OF WHYTE GARDENS, UNDER NO CIRCUMSTANCES SHALL TRANSFER OF THIS DOCUMENT BE DEEMED A SALE. THE CONTRACTOR SHALL VERIFY JOB DIMENSIONS PRIOR TO ANY WORK COMMENCING. FIGURED DIMENSIONS TAKE PRECEDENCE OVER SCALED WORK

CANTERBURY CLIENT

NEW AUTOMATIC LOUVRED PERGOLA TO BE INSTALLED TO MATCH HEIGHT OF EXISTING EAVE OVERHANG. PERGOLA TO HAVE POWDERCOATED - ALUMINIUM FINISH TO THE POSTS, BULKHEAD AND LOUVRES. POWDERCOATED COLOURS TO MATCH EXISTING EXTERIOR FINISHES AS PER THE

DRAWING TITLE	ISSUE	DRAWING TYPE	DATE	DR
HARDSCAPE PLAN	1	REVISION AS PER EMAIL: 28/09/20	29/09/20	ZC
	2	CHANGES TO INCLUDE WATER FEATURE	02/03/21	
ISSUE				PAG

FORCONSTRUCTION - 22/09/2020

DRAWN PAGE SIZE NORTH




A2

PAGE NO. 04 of 9

LANDSCAPE PLANTING PLAN - REAR 1:50 @ A2

1:100 @ A2

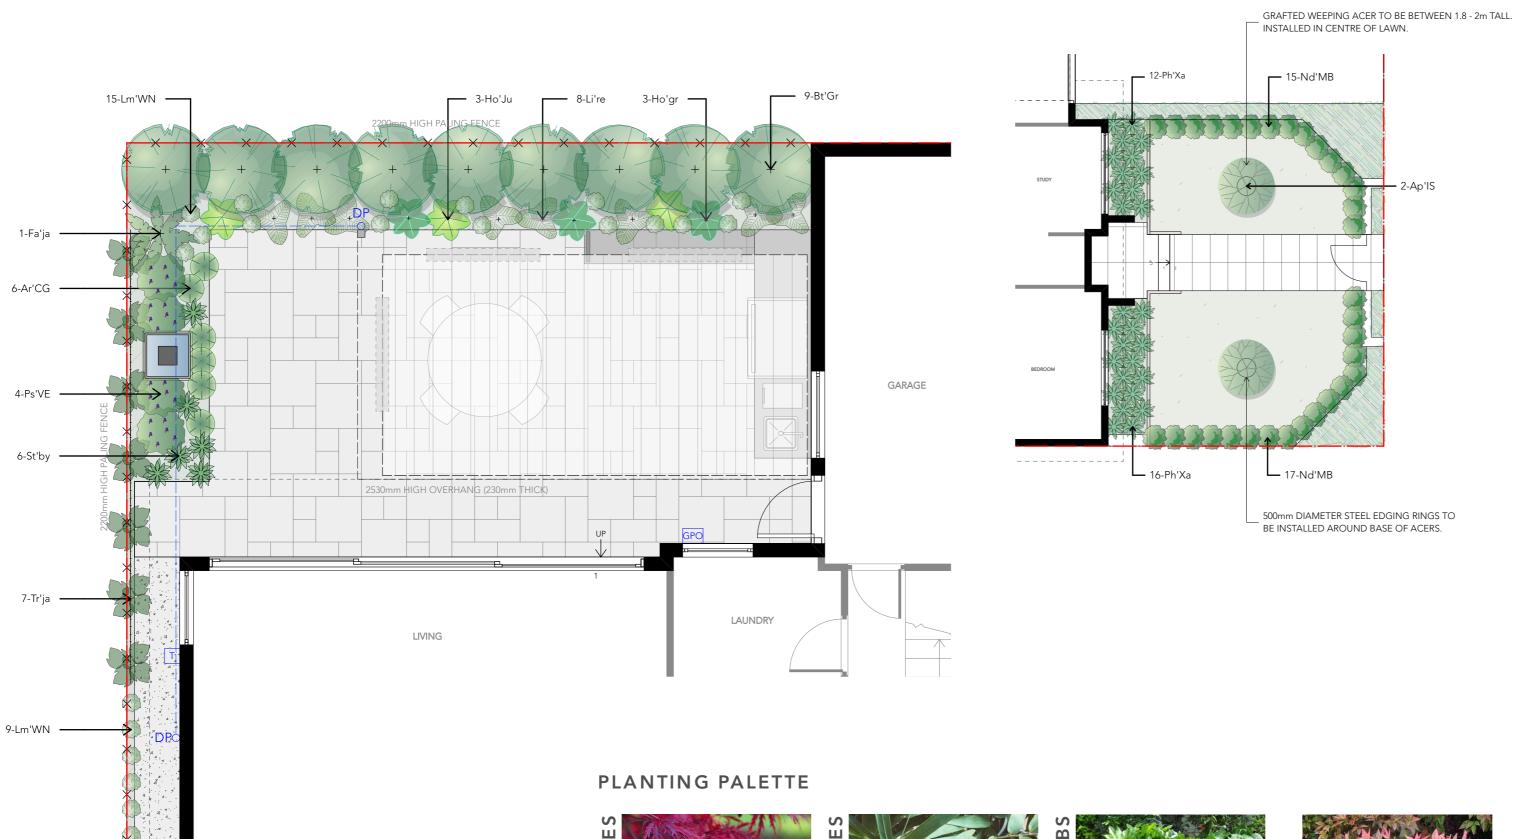







Carpet Bugle



Bambusa textilis 'Gracilis' Slender Weavers Bamboo



Hosta grandiflora Large Flowered Hosta



94 Milton Parade Malvern, Vic 3144 (03) 9017 4344 PH: EMAIL: admin@whytegardens.com.au WEB: www.whytegardens.com.au ABN: 51 121 922 361



IN ACCEPTING AND UTILISING THIS DOCUMENT THE RECIPIENT AGREES THAT WHYTE GARDENS ABN 51 121 922 361 RETAINS ALL COMMON LAW, STATUARY LAW AND OTHER RIGHTS INCLUDING COPYRIGHT AND INTELLECTUAL PROPERTY RIGHTS. THE RECIPIENT AGREES NOT TO USE THIS DOCUMENT FOR ANY PURPOSE OTHER THAN ITS INTENDED USE; TO WAIVE ALL CLAIMS AGAINST WHYTE GARDENS RESULTING FROM UNAUTHORISED CHANGES; OR TO REUSE THIS DOCUMENT ON OTHER PROJECTS WITHOUT PRIOR WRITTEN CONSENT OF WHYTE GARDENS. UNDER NO CIRCUMSTANCES SHALL TRANSFER OF THIS DOCUMENT BE DEEMED A SALE. THE CONTRACTOR SHALL VERIFY JOB DIMENSIONS PRIOR TO ANY WORK COMMENCING. FIGURED DIMENSIONS TAKE PRECEDENCE OVER SCALED WORK.

PROJECT SITE FAVERSHAM RD, CANTERBURY

CLIENT

June Plantain Lily



Fatsia japonica

Japanese Aralia

LANDSCAPE PLANTING PLAN - FRONT

PLANT SCHEDULE

	ID	BOTANICAL NAME	COMMON NAME	POT SIZE	QTY
DECIDUOUS TREES					
	Ap'IS	Acer palmatum dissectum 'Inabe Shidare'	Japanese Weeping Maple	50 cm	2
EVERGREEN TREES					
💮 Bt'Gr Bambusa textilis 'Gracilis'		Slender Weavers Bamboo	30 cm	9	
SHRUBS					
×	🖡 Fa'ja Fatsia japonica		Japanese Aralia	20 cm	1
۲	Nd'MB	Nandina domestica 'Moon Bay'	Dwarf Sacred Bamboo	20 cm	32
赣	Ph'Xa Philodendron hybrid 'Xanadu'		Philodendron Xanadu	20 cm	28
	Ps'VE Plectranthus saccatus 'Velvet Elvis'		Plectranthus 'Velvet Elvis'	14 cm	4
PERENNIALS					
	Ar'CG	Ajuga reptans 'Catlin's Giant'	Carpet Bugle	14 cm	6
*	Ho'Ju	Hosta 'June'	June Plantain Lily	25 cm	3
*	Ho'gr	Hosta grandiflora	Large Flowered Hosta	25 cm	3
~	Ui're Ligularia reniformis		Tractor Seat Plant	14 cm	8
GROUND C	OVERS				
	Lm'WN	Lamium maculatum 'White Nancy'	Spotted Dead Nettle	14 cm	24
*	St'by Stachys byzantina		Lamb's Ears	14 cm	6
CLIMBERS					
Tr'ja		Trachelospermum jasminoides	Chinese Star Jasmine	14 cm	7
TOTAL PLANTS					133










DRAWING TITLE

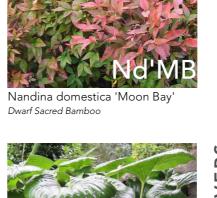



Ligularia reniformis Tractor Seat Plant



Philodendron 'Xanadu'



Lamium maculatum 'White Nancy' Spotted Dead Nettle



Plectranthus saccatus 'Velvet Elvis' Plectranthus 'Velvet Elvis'



DATE

29/09/20

02/03/21

Stachys byzantina Lamb's Ears



Chinese Star Jasmine

DRAWN PAGE SIZE NORTH **A2**




PLANTING PLAN & SCHEDULE

ISSUE FORCONSTRUCTION - 22/09/2020

- ISSUE DRAWING TYPE 1 REVISION AS PER EMAIL: 28/09/20
- 2 CHANGES TO INCLUDE WATER FEATURE
- PAGE NO. 05 of 9

ZC

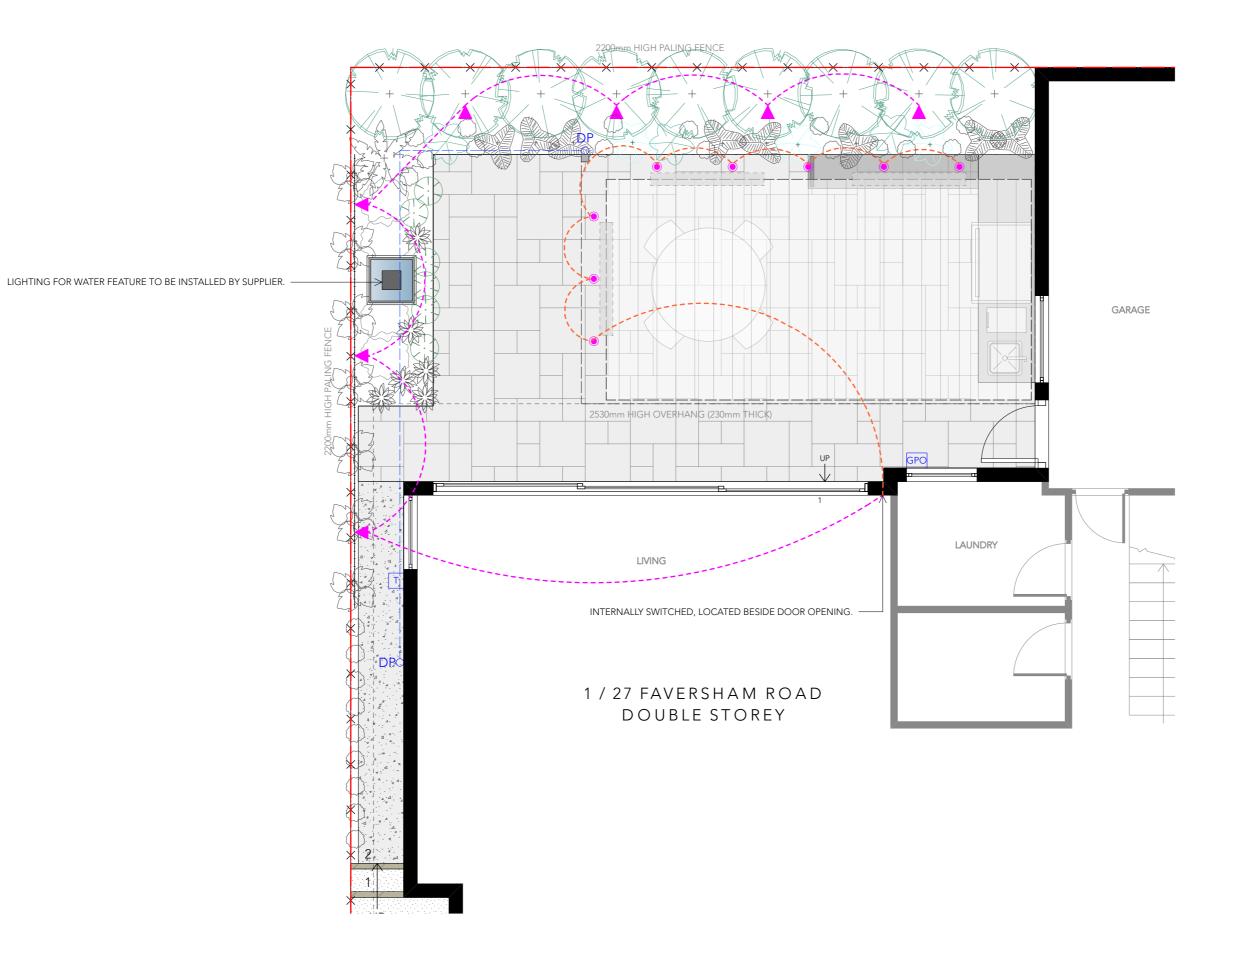

LIGHTING SCHEDULE

Cir-1			ACCENT LIGHT - 12volt LED AQUALUX PHOENIX SERIES SPIKE LIGHT ID: AQL-503-BK-M Finish: MATT BLACK	4WATT LED 300lm WARM WHITE LED	Smart Water Shop Ph: 9808 4067 39/41 Huntingdale Rd Burwood	07
Cir-2	۲	V	DOWN LIGHT ADJUSTABLE RECESSED LED LIGHT	WARM WHITE LED	TO BE SELECTED BY PERGOLA CONTRACTOR	08*

NOTE:

* POSITION AND AMOUNT OF PERGOLA LIGHTS SHOWN INDICATIVELY ON PLAN, CONTRACTOR TO DETERMINE FINAL LAYOUT AND SPECIFICATIONS.

• ALL GLOBES ARE TO BE WARM WHITE GLOBES. • ELECTRICIAN WILL BE REQUIRED TO INSTALL INTERNAL SWITCHES AND EXTERNAL POWER OUTLETS IN THE DESIRED

LOCATIONS.

• ALLOW FOR APPROPRIATE SIZE CONDUIT UNDER PATHWAY/ PAVING SLABS FOR ELECTRICAL CABLING WHERE NECESSARY



94 Milton Parade Malvern, Vic 3144 PH: (03) 9017 4344 EMAIL: admin@whytegardens.com.au WEB: www.whytegardens.com.au



IN ACCEPTING AND UTILISING THIS DOCUMENT THE RECIPIENT AGREES THAT WHYTE GARDENS ABN 51 121 922 361 RETAINS ALL COMMON LAW, STATUARY LAW AND OTHER RIGHTS INCLUDING COPYRIGHT AND INTELLECTUAL PROPERTY RIGHTS. THE RECIPIENT AGREES NOT TO USE THIS DOCUMENT FOR ANY PURPOSE OTHER THAN ITS INTENDED USE; TO WAIVE ALL CLAIMS AGAINST WHYTE GARDENS RESULTING FROM UNAUTHORISED CHANGES; OR TO REUSE THIS DOCUMENT ON OTHER PROJECTS WITHOUT PRIOR WRITTEN CONSENT OF WHYTE GARDENS. UNDER NO CIRCUMSTANCES SHALL TRANSFER OF THIS DOCUMENT FE DEEMED A SALE. THE CONTRACTOR SHALL VERIFY JOB DIMENSIONS TAKE PRECEDENCE OVER SCALED WORK.

DRAWING TITLE LIGHTING PLAN & SCHEDULE

ISSUE FORCONSTRUCTION - 22/09/2020

ISSUE DRAWING TYPE

1 REVISION AS PER EMAIL: 28/09/20

2 CHANGES TO INCLUDE WATER FEATURE

DATE 29/09/20 02/03/21

DRAWN PAGE SIZE NORTH **A2**



PAGE NO. 06 of 9

ZC

MATERIALS & FINISHES SCHEDULE

ID	IMAGES	DETAILS		SUPPLIER	LOCATION	NOTES
HARD	LANDSCAPING					
F01		ITEM: PRODUCT: FINISH: SIZE: PATTERN: GROUT:	PAVING 'GARONNE' LIMESTONE TUMBLED 917 / 610 / 303mm FORMAT MODULAR / ASHLAR 'MANHATTAN 2000' MAPEI 110	ECO OUTDOOR 422 BURNLEY STREET RICHMOND VIC 3121 (03) 9413 3222	• REAR GARDEN PAVING	
F02		ITEM: MIX: BASE COLOUR: FINISH:	EXPOSED AGGREGATE BURRINDI OFF WHITE BASE EXPOSED	MENTONE PREMIX 18 SHEARSON CRES, MENTONE (03) 9584 2863	• SIDEWAY PATH	
F03		ITEM: PRODUCT: SIZE:	POCELAIN BENCH TOP DEKTON 'KRETA' (TBC) or SIMILAR 3020 x 750 x 12mm (REFER TO CONTRACTORS DETAILS)	CONTRACTOR TO SOURCE	BARBECUE BENCH TOP BENCH SEAT (TBC)	• BENHTOP TO HAVE 100mm PROFILE AND 100mm SPLASHBACK • WATERFALL EDGE DETAIL
F04		ITEM: TYPE: FINISH: SIZE:	LOUVRED ROOF AUTOMATIC LOUVRES POWDERCOATED ALUMINIUM 6000 x 3300mm	LOUVRE HOUSE 9 CENTRAL BOULEVARD PORT MELBOURNE VIC 3207 1800 568 873	• OVERHEAD STRUCTURE	• TO MATCH HEIGHT OF EXISTING EAVE • REFER TO CONTRACTORS DETAILS
F05		ITEM: PRODUCT: THICKNESS: APERTURE:	STEEL MESH SL52 REINFORCING MESH 5mm 200 x 200mm	BUNNINGS or SIMILAR	• SIDEWAY VERTICAL SCREENS	• SECURED TO TIMBER POSTS
F06		ITEM: TYPE: SIZE: PEBBLES:	WATER FEATURE SQUARE GRIND COLUMN COLUMN: 1600 x 250 x 250mm POND: 250 x 600 x 600mm VOLCANIC BLACK	WATER FEATURES DIRECT 195-197 QUEENS PARADE CLIFTON HILL, VIC 3068 (03) 9486 8323	• REAR GARDEN WATER FEATURE	INSTALLED ONTO 650mm SQUARE BASE • TO BE INSTALLED AS PER MANUFACTURERS SPECIFICATIONS
SOFT	LANDSCAPING					
S01		ITEM: PRODUCT:	MULCH MULCH MASTER	C.FULTONS GARDEN SUPPLIES - HAWTHORN - CHELTENHAM - WANTIRNA - ALPHINGTON	• ALL PROPOSED GARDEN BEDS	



MATERIALS & FINISHES SCHEDULE

ID	IMAGES	DETAILS			SUF	PLIER	LOCATION	NOTES		
SOFT LANDSCAPING										
SE		ITEM: PRODUCT: THICKNESS: DIAMETER: PROFILE HEIGHT:	EDGINC MILD ST 2 mm 500mm 150 mm	EEL	CONT	RACTOR TO CE	• FRONT GARDEN EDGING	RODS, S	USING STEEL IECURED TO CK OF THE ACE.	
FITTINGS AND FEATURES										
E01		TYPE: PRODUCT: MODEL: FINISH: SIZE:	BBQ WEBER SUMMIT E-660 6 BURNER BUILT-IN BBQ E-660 Natural Gas BLACK & STAINLESS STEEL 1067 x 788 x 1283/1474mm (LxWxH Hood Closed/Open)		CONT	RACTOR TO CE	• OUTDOOR KITCHEN			
E02		TYPE: PRODUCT: MODEL: FINISH: SIZE:	BEEFEATER SIGNATURE PROLINE BUILT-IN SIDE BURNER WITH LID BSW318SA-NG		- OUT 28 LIC MOUN PH: 13	ESTED: DOORS DOMAIN DNEL ROAD, NT WAVERLY 300 794 839	OUTDOOR KITCHEN			
E03		TYPE: PRODUCT: MODEL: FINISH:	SINK & TAPS INNOVA SINGLE BOWL & YORK STRAIGHT SPOUT PULL OUT MIXER SR-4545 & BL3110P STAINLESS STEEL			INTED RACTOR TO CE	• OUTDOOR KITCHEN	BENCH COVERI	O BE ED INTO WITH LID NG TO MATCH TOP FINISH	
PAINT	& FINISH COLOUR	S								
P01		TYPE: FINISH:	COLORI	BOND POWDERCOAT ÆNT		INTED RACTOR TO CE	• PERGOLA FRAME & POSTS			
P02		TYPE: FINISH:	COLORBOND POWDERCOAT SURF MIST (TBC WITH CONTRACTOR)			INTED RACTOR TO CE	• PERGOLA LOUVRES			
P03		TYPE: FINISH:	COLORBOND POWDERCOAT C/B 'NIGHT SKY' MATT or BLACK TO MATCH BBQ CABINETRY			INTED RACTOR TO CE	• KITCHEN BENCH CABINETRY • BENCH SEAT SLEIGH LEG SUPPORT			
		Milton Dovo d		PROJECT SITE		PAGE TITLE			SHEET NO.	
94 Milton Parade, Malvern, Victoria 3144 PROJECT SITE PAGE TITLE SHEE Malvern, Victoria 3144 FAVERSHAM RD, MATERIALS & FINISHES SCHEDULE 2 Apx										

PH: (03) 9017 4344 EMAIL: admin@whyte.net.au WEB: www.whytegardens.com.au ABN: 51 121 922 361

WHYTE

G/RDENS

CANTERBURY CLIENT

MATERIALS & FINISHES SCHEDULE 2 Apx.02 ISSUE DRAWING TYPE DATE 2 02/03/21 ZC

